



# VETERANS STREET RECONSTRUCT

JENKINS, MINNESOTA  
MARCH, 2026

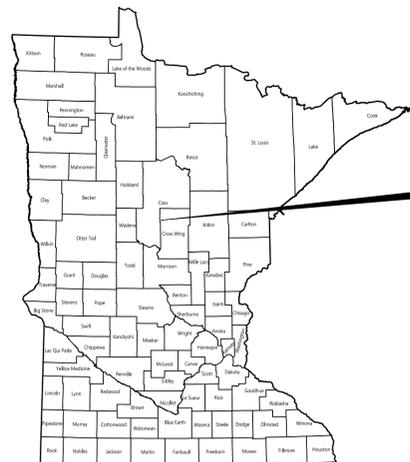

**PROJECT LOCATION**  
CITY OF JENKINS

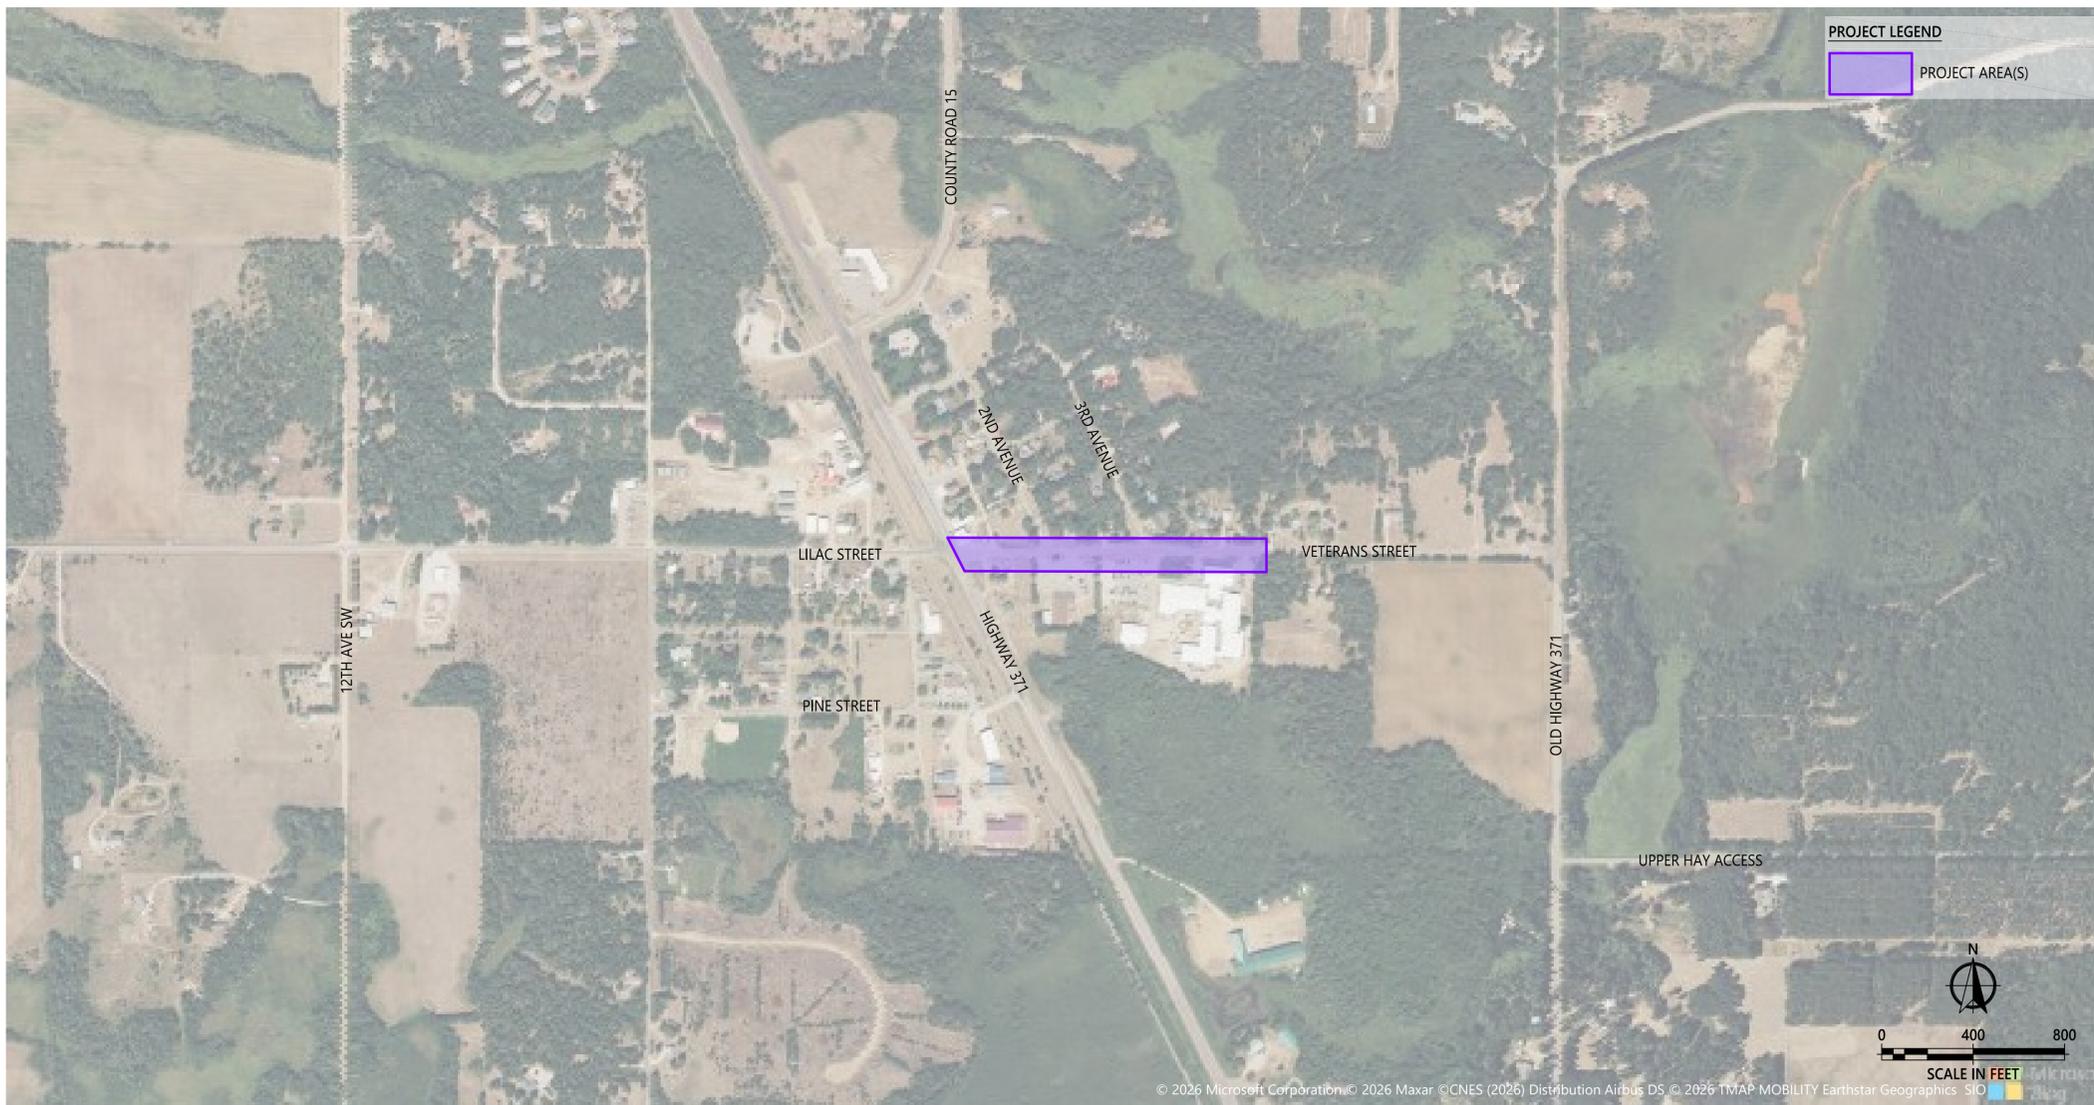

**PROJECT LEGEND**

PROJECT AREA(S)

**GOVERNING SPECIFICATIONS**  
THE 2025 EDITION OF THE MINNESOTA DEPARTMENT OF TRANSPORTATION "STANDARD SPECIFICATIONS FOR CONSTRUCTION" AND THE 2023 SCHEDULE OF "MATERIALS CONTROL FOR 2020 STANDARD SPECIFICATIONS" SHALL GOVERN.

**CITY OFFICIALS**

MAYOR: Andrew Ruglang  
CITY COUNCIL: Jerimey Flategraff  
Roman Siltman  
Ryan Barnett  
Jory Carlson

CITY CLERK-TREASURER: Cassandra Delougherty  
PUBLIC WORKS SUPERVISOR:

**APPROVALS**

RECOMMENDED FOR APPROVAL: \_\_\_\_\_ DATE \_\_\_\_\_  
CITY CONSULTING ENGINEER

**SHEET INDEX TABLE**

SHEET No.	SHEET TITLE
C1.01	TITLE SHEET
C1.02	LEGEND
C1.03	STATEMENT OF ESTIMATED QUANTITIES
C2.01	TYPICAL SECTIONS
C3.01 - C3.05	DETAILS
C4.01 - C4.02	EROSION CONTROL & REMOVALS
C5.01 - C5.02	SWPPP
C6.01 - C6.02	PLAN & PROFILE
C7.01 - C7.02	TURF ESTABLISHMENT

THIS PLAN CONTAINS **17** SHEETS

MAP SOURCE & YEAR: [YEAR] [MAP SOURCE]  
MAP DESCRIPTION: [DESCRIPTION OF MAP, I.E. PARTIAL MAP OF BAXTER, CROW WING COUNTY, MINNESOTA]

**THIS PLAN SET CONTAINS COLOR GRAPHICS. BLACK AND WHITE PRINTS ARE NOT OFFICIAL SIGNED DOCUMENTS.**



DRAWN BY: TMR  
CHECKED BY: DSR  
THOMAS RIENS LIC. NO.: 63111 DATE: MM/DD/YYYY

DATE	REV#	REVISIONS DESCRIPTION

**VETERANS STREET RECONSTRUCT**  
TITLE SHEET

**C1.01**  
PROJECT #: 2026-10527

© 2026 WIDSETH ARCHITECTS • ENGINEERS • SCIENTISTS • SURVEYORS FILE: W:\PROJECTS\CITY OF JENKINS-32482\2026-10527\04 DESIGN\CIVIL\CADD\C-1S-2026-10527.DWG PLOTTED BY: THOMAS RIENS, March 17, 2026

**SURVEY MONUMENTS - FOUND**

- FOUND CAST IRON MONUMENT
- FOUND CONTROL POINT
- FOUND IRON PIPE
- FOUND JUDICIAL LAND MONUMENT
- FOUND LATH

**SURVEY MONUMENTS - STAKED**

- BENCHMARK
- STAKED CAST IRON MONUMENT
- STAKED CONTROL POINT
- STAKED IRON PIPE
- STAKED JUDICIAL LAND MONUMENT

**PROPERTY LINEWORK**

- SECTION LINE
- QUARTER SECTION LINE
- QUARTER QUARTER SECTION LINE
- RIGHT-OF-WAY LINE
- EASEMENT LINE
- DESCRIPTION LINE
- DEEDED LOT LINE
- PLATTED LOT LINE
- BOUNDARY LINE
- SUBDIVISION LINE
- SETBACK LINE

**TOPOGRAPHIC INFORMATION - EXISTING**

- 1230 MAJOR CONTOURS
- 1234- MINOR CONTOURS
- + 1234.56 SPOT ELEVATION

**TOPOGRAPHIC INFORMATION - PROPOSED**

- 1230 MAJOR CONTOURS (WITH LABEL)
- 1234- MINOR CONTOURS (WITH LABEL)
- 1234.56 SPOT ELEVATION
- +/-1.23% SLOPE - PERCENT
- 1:2 SLOPE - RISE : RUN
- TBC: 1234.56 / FLW: 1234.06 SPOT ELEVATIONS @ CURB (TBC: TOP BACK CURB / FLW: CURB FLOWLINE)
- +1.23, -3.21 SPOT ELEVATIONS, CUT/FILL (GREEN: FILL DEPTH / RED: CUT DEPTH)

**VEGETATION SYMBOLS - EXISTING**

- SHRUB
- STUMP
- TREE - CONIFEROUS
- TREE - DECIDUOUS
- WETLAND

**VEGETATION LINEWORK - EXISTING**

- EDGE OF WOODS
- EDGE OF WETLANDS

**VEGETATION SYMBOLS - PROPOSED**

- SHRUB
- TREE - CONIFER
- TREE - DECIDUOUS

**VEGETATION LINEWORK - PROPOSED**

- EDGE OF WOODS

**ROADWAY/PAVEMENT LINEWORK - EXISTING**

- BITUMINOUS SURFACE
- CONCRETE SURFACE
- CURB & GUTTER
- GRAVEL SURFACE
- ROADWAY/DRIVE/TRAIL CENTERLINE

**ROADWAY/PAVEMENT LINEWORK - PROPOSED**

- BITUMINOUS SURFACE
- CONCRETE SURFACE
- CURB & GUTTER
- GRAVEL SURFACE
- ROADWAY/DRIVE/TRAIL CENTERLINE

**SITE SYMBOLS - EXISTING**

- FENCE POST
- FLAG POLE
- GUARD POST (BOLLARD)
- GUY POLE
- GUY WIRE ANCHOR
- ACCESSIBLE PARKING MARKING
- MAILBOX
- SIGN - DOUBLE POST
- SIGN - SINGLE
- SIGN - FIRE #

**SITE LINEWORK - EXISTING**

- BUILDING
- BARB WIRE FENCE
- CHAINLINK FENCE
- WOOD FENCE
- RAILROAD
- RETAINING WALL

**SITE SYMBOLS - PROPOSED**

- FENCE POST
- FLAG POLE
- GUARD POST (BOLLARD)
- GUY POLE
- GUY WIRE ANCHOR
- MAILBOX
- SIGN - DOUBLE POST
- SIGN - FIRE #
- SIGN - SINGLE

**SITE LINEWORK - PROPOSED**

- BUILDING
- FENCE - BARB WIRE
- FENCE - CHAINLINK
- FENCE - WOOD
- RETAINING WALL

**COMMUNICATION/TELECOM UTILITY SYMBOLS - EXISTING**

- TELECOM HANDHOLE
- TELECOM MANHOLE
- TELECOM PEDESTAL
- TELECOM POLE
- TV HANDHOLE
- TV PEDESTAL
- SATELLITE DISH

**COMMUNICATION/TELECOM UTILITY LINEWORK - EXISTING**

- UNDERGROUND FIBER OPTIC LINE
- OVERHEAD TELEPHONE LINE
- UNDERGROUND TELEPHONE LINE
- OVERHEAD TV LINE
- UNDERGROUND TV LINE

**COMMUNICATION/TELECOM UTILITY SYMBOLS - PROPOSED**

- TELECOM HANDHOLE
- TELECOM MANHOLE
- TELECOM PEDESTAL
- TELECOM POLE
- TV HANDHOLE
- TV PEDESTAL
- SATELLITE DISH

**COMMUNICATION/TELECOM UTILITY LINEWORK - PROPOSED**

- UNDERGROUND FIBER OPTIC LINE
- UNDERGROUND TELEPHONE LINE
- OVERHEAD TV LINE
- UNDERGROUND TV LINE

**ELECTRICAL UTILITY SYMBOLS - EXISTING**

- AC UNIT
- GENERATOR
- GROUND LIGHT (FLOODLIGHT)
- ELECTRIC HANDHOLE
- LIGHT POLE
- ELECTRIC MANHOLE
- ELECTRIC METER
- ELECTRIC PEDESTAL
- ELECTRIC POLE
- TRAFFIC SIGNAL
- TRANSFORMER
- YARD LIGHT

**ELECTRICAL UTILITY LINEWORK - EXISTING**

- OVERHEAD ELECTRIC LINE
- UNDERGROUND ELECTRIC LINE

**ELECTRICAL UTILITY SYMBOLS - PROPOSED**

- AC UNIT
- GENERATOR
- GROUND LIGHT (FLOODLIGHT)
- ELECTRIC HANDHOLE
- LIGHT POLE
- ELECTRIC MANHOLE
- ELECTRIC METER
- ELECTRIC PEDESTAL
- ELECTRIC POLE
- TRAFFIC SIGNAL
- TRANSFORMER
- YARD LIGHT

**ELECTRICAL UTILITY LINEWORK - PROPOSED**

- OVERHEAD ELECTRIC LINE
- UNDERGROUND ELECTRIC LINE

**NATURAL GAS UTILITY SYMBOLS - EXISTING**

- NATURAL GAS METER
- NATURAL GAS VALVE
- PROPANE TANK

**NATURAL GAS UTILITY LINEWORK - EXISTING**

- NATURAL GAS LINE

**NATURAL GAS UTILITY SYMBOLS - PROPOSED**

- NATURAL GAS METER
- NATURAL GAS VALVE
- PROPANE TANK

**NATURAL GAS UTILITY LINEWORK - PROPOSED**

- NATURAL GAS LINE

**SANITARY SEWER SYMBOLS - EXISTING**

- SANITARY AIR RELEASE MANHOLE
- SANITARY CLEANOUT
- LIFT STATION WET WELL
- LIFT STATION VALVE VAULT
- SANITARY MANHOLE
- SANITARY VALVE (FORCEMAIN)

**SANITARY SEWER LINEWORK - EXISTING**

- SANITARY FORCE MAIN
- SANITARY GRAVITY MAIN
- SANITARY SERVICE LINE

**SANITARY SEWER SYMBOLS - PROPOSED**

- SANITARY AIR RELEASE MANHOLE
- SANITARY CLEANOUT
- LIFT STATION WET WELL
- LIFT STATION VALVE VAULT
- SANITARY MANHOLE
- SANITARY VALVE (FORCEMAIN)

**SANITARY SEWER LINEWORK - PROPOSED**

- SANITARY FORCE MAIN
- SANITARY GRAVITY MAIN
- SANITARY SERVICE LINE

**STORM SEWER SYMBOLS - EXISTING**

- STORM SEWER CATCH BASIN
- STORM SEWER CLEANOUT
- CULVERT APRON
- STORM SEWER INLET STRUCTURE
- STORM SEWER MANHOLE

**STORM SEWER LINEWORK - EXISTING**

- STORM SEWER GRAVITY MAIN
- STORM SEWER DRAINTILE

**STORM SEWER SYMBOLS - PROPOSED**

- STORM SEWER CATCH BASIN
- STORM SEWER CLEANOUT
- STORM SEWER INLET STRUCTURE
- STORM SEWER MANHOLE

**STORM SEWER LINEWORK - PROPOSED**

- STORM SEWER GRAVITY MAIN
- STORM SEWER DRAINTILE

**WATER SYMBOLS - EXISTING**

- CURB STOP
- WATER HANDHOLE
- FIRE HYDRANT
- YARD HYDRANT
- WATER MANHOLE
- WATER METER
- WATER MAIN VALVE
- WATER WELL

**WATER LINEWORK - EXISTING**

- WATER MAIN LINE
- WATER SERVICE LINE


**WATER SYMBOLS - PROPOSED**


- CURB STOP
- HANDHOLE
- HYDRANT
- YARD HYDRANT
- MANHOLE
- WATER METER
- WATER MAIN VALVE
- WATER WELL

**WATER LINEWORK - PROPOSED**


- WATER MAIN PIPE
- WATER SERVICE PIPE

© 2026 WIDSETH. FILE: W:\PROJECTS\CITY OF JENKINS-32482\2026-10527\04 DESIGN\CIVIL\CADD\C-10-2026-10527.DWG - PLOTTED BY: THOMAS RIENS, March 17, 2026

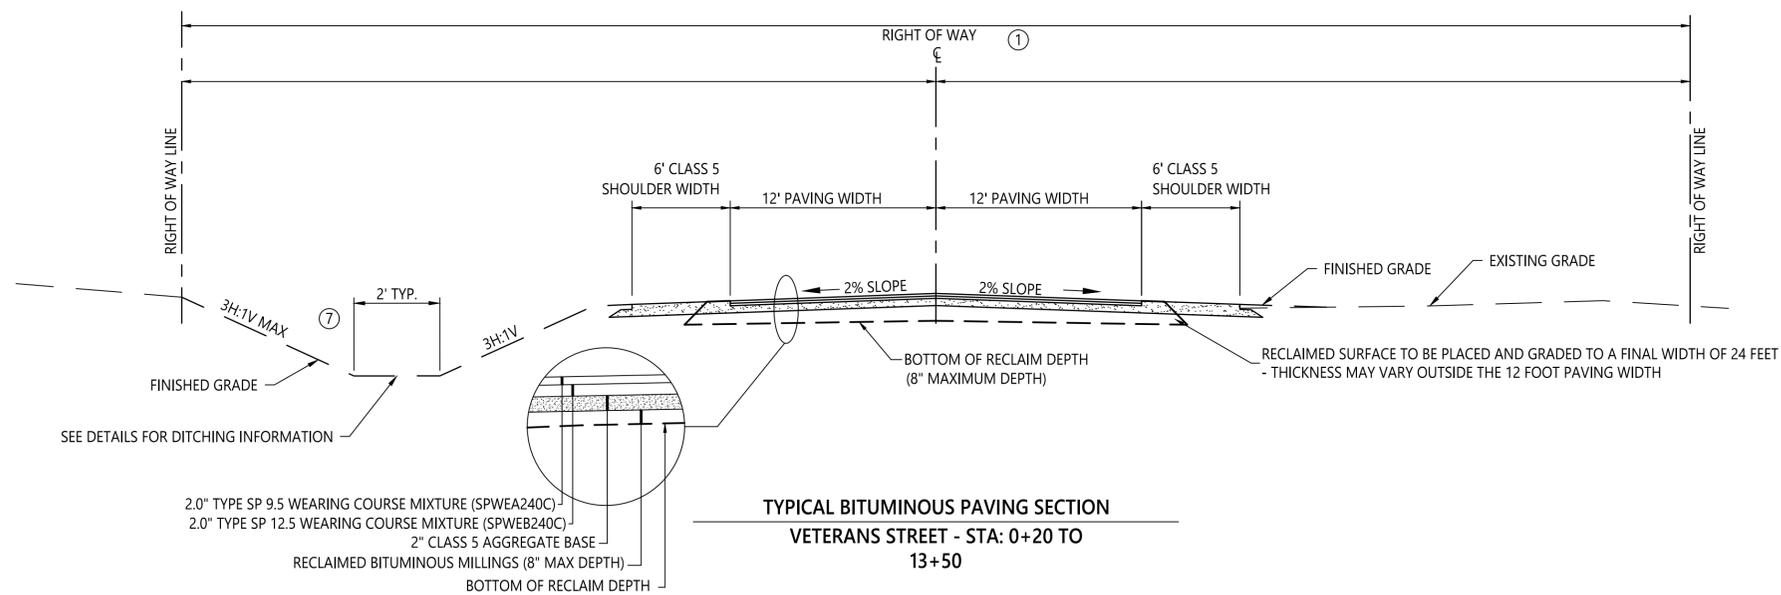

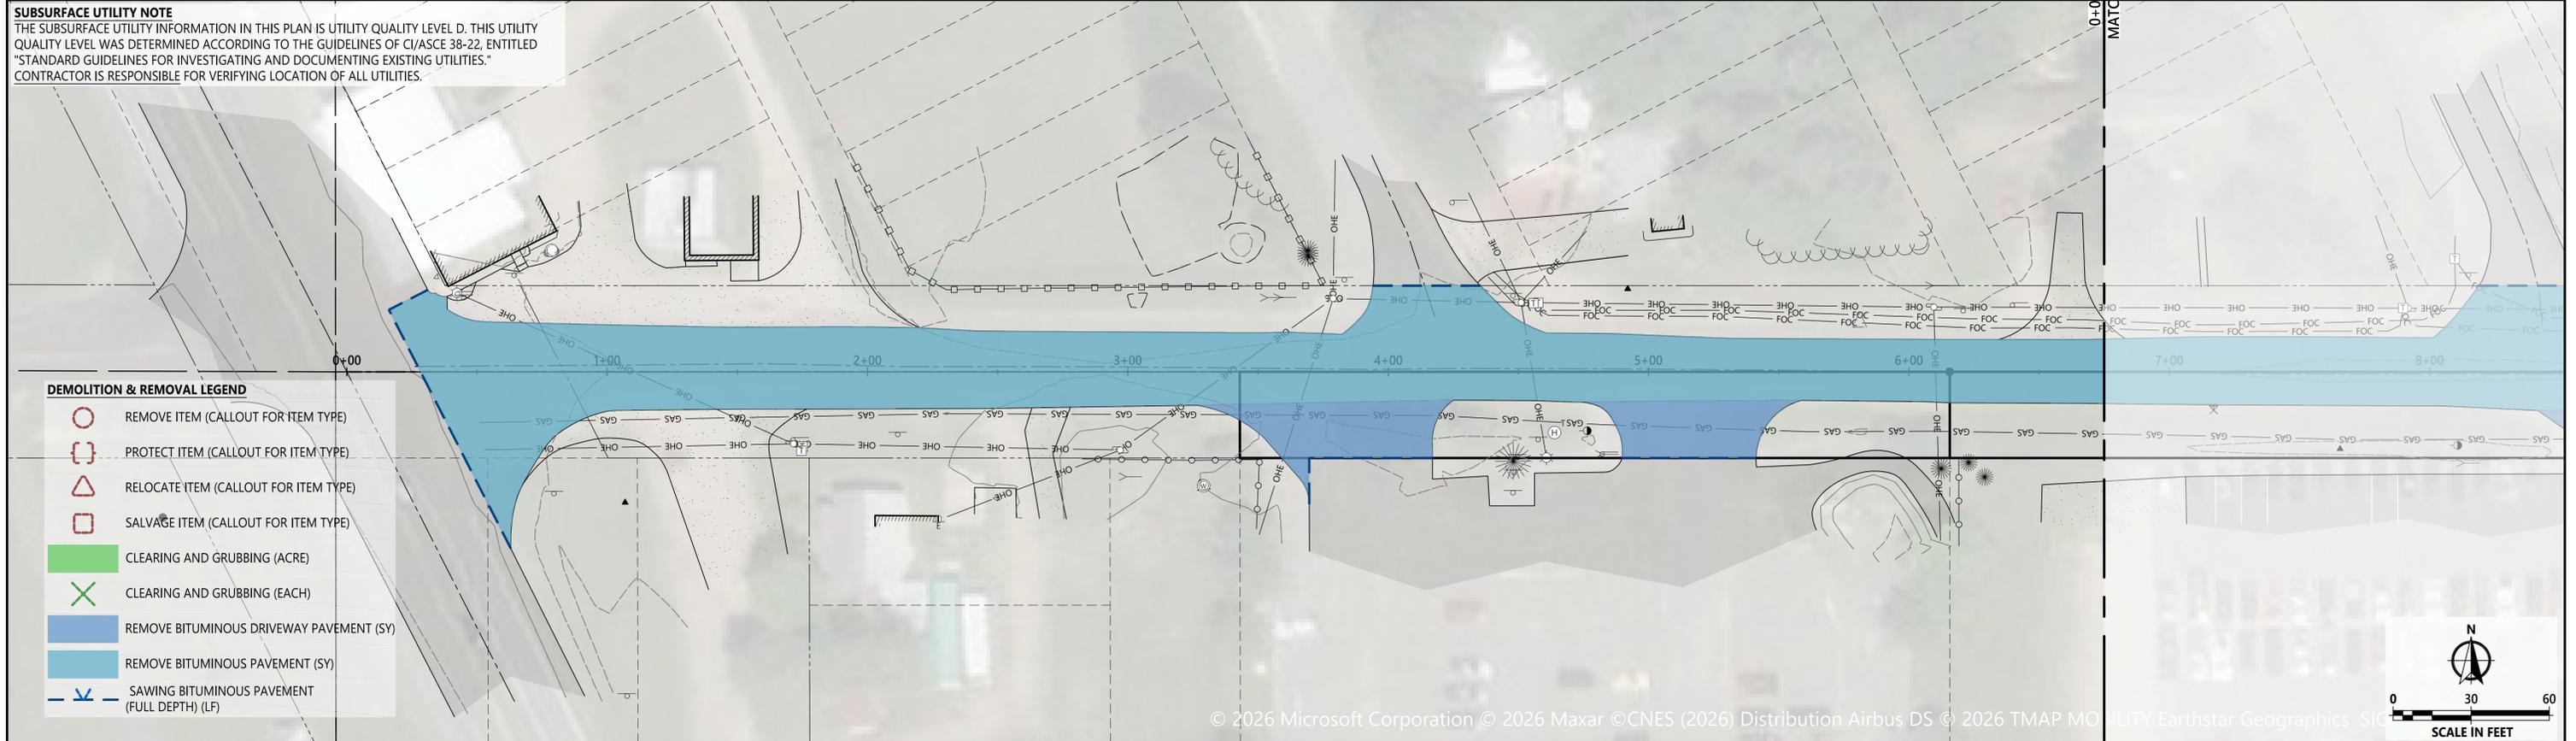

# REMOVALS AND EROSION CONTROL PLAN

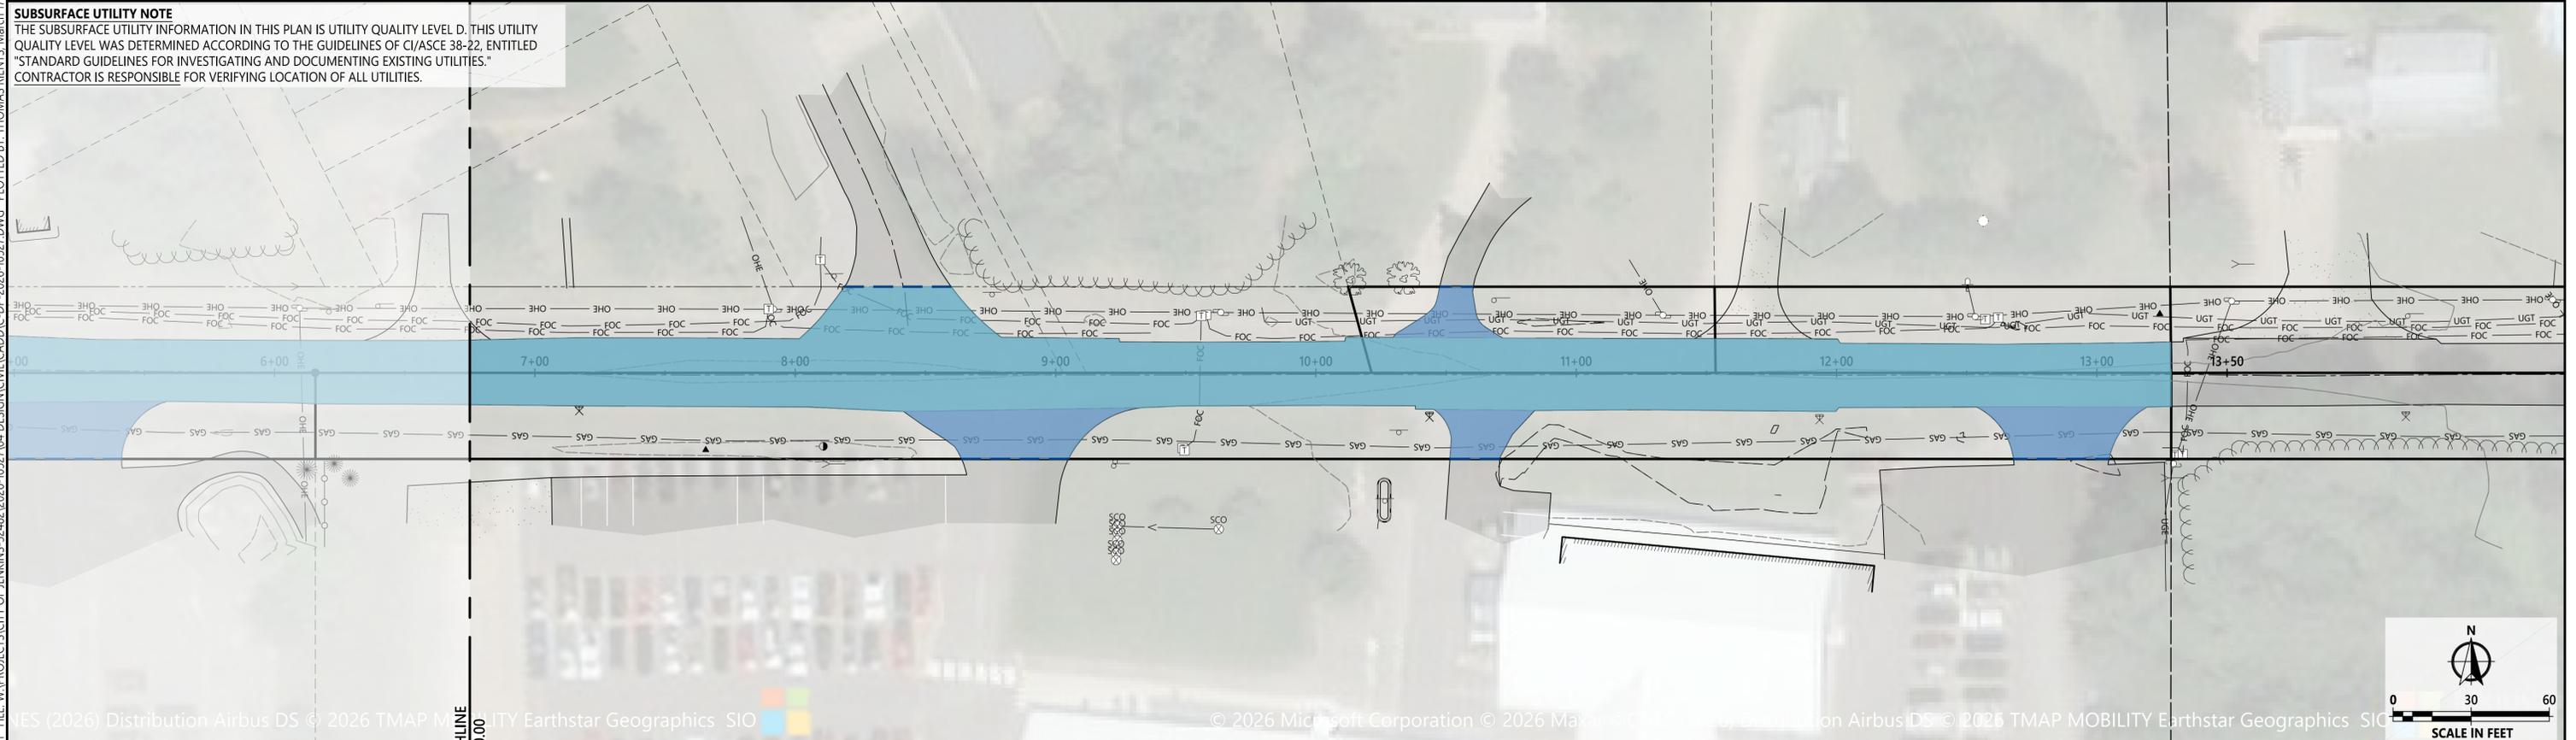

© 2026 WIDSETH FILE: W:\PROJECTS\CITY OF JENKINS-32482\2026-10527\04 DESIGN\CIVIL\CADD\CDP-2026-10527.DWG PLOTTED BY: THOMAS RIENTS, March 17, 2026

**WIDSETH**  
ARCHITECTS • ENGINEERS • SCIENTISTS • SURVEYORS


DRAWN BY: TMR  
CHECKED BY: DSR  
THOMAS RIENTS LIC. NO.: 63111 DATE: MM/DD/YYYY

DATE	REV#	REVISIONS DESCRIPTION


**VETERANS STREET RECONSTRUCT**  
REMOVALS AND EROSION CONTROL PLAN

**C4.01**  
PROJECT #: 2026-10527


**SUBSURFACE UTILITY NOTE**  
 THE SUBSURFACE UTILITY INFORMATION IN THIS PLAN IS UTILITY QUALITY LEVEL D. THIS UTILITY QUALITY LEVEL WAS DETERMINED ACCORDING TO THE GUIDELINES OF CI/ASCE 38-22, ENTITLED "STANDARD GUIDELINES FOR INVESTIGATING AND DOCUMENTING EXISTING UTILITIES." CONTRACTOR IS RESPONSIBLE FOR VERIFYING LOCATION OF ALL UTILITIES.

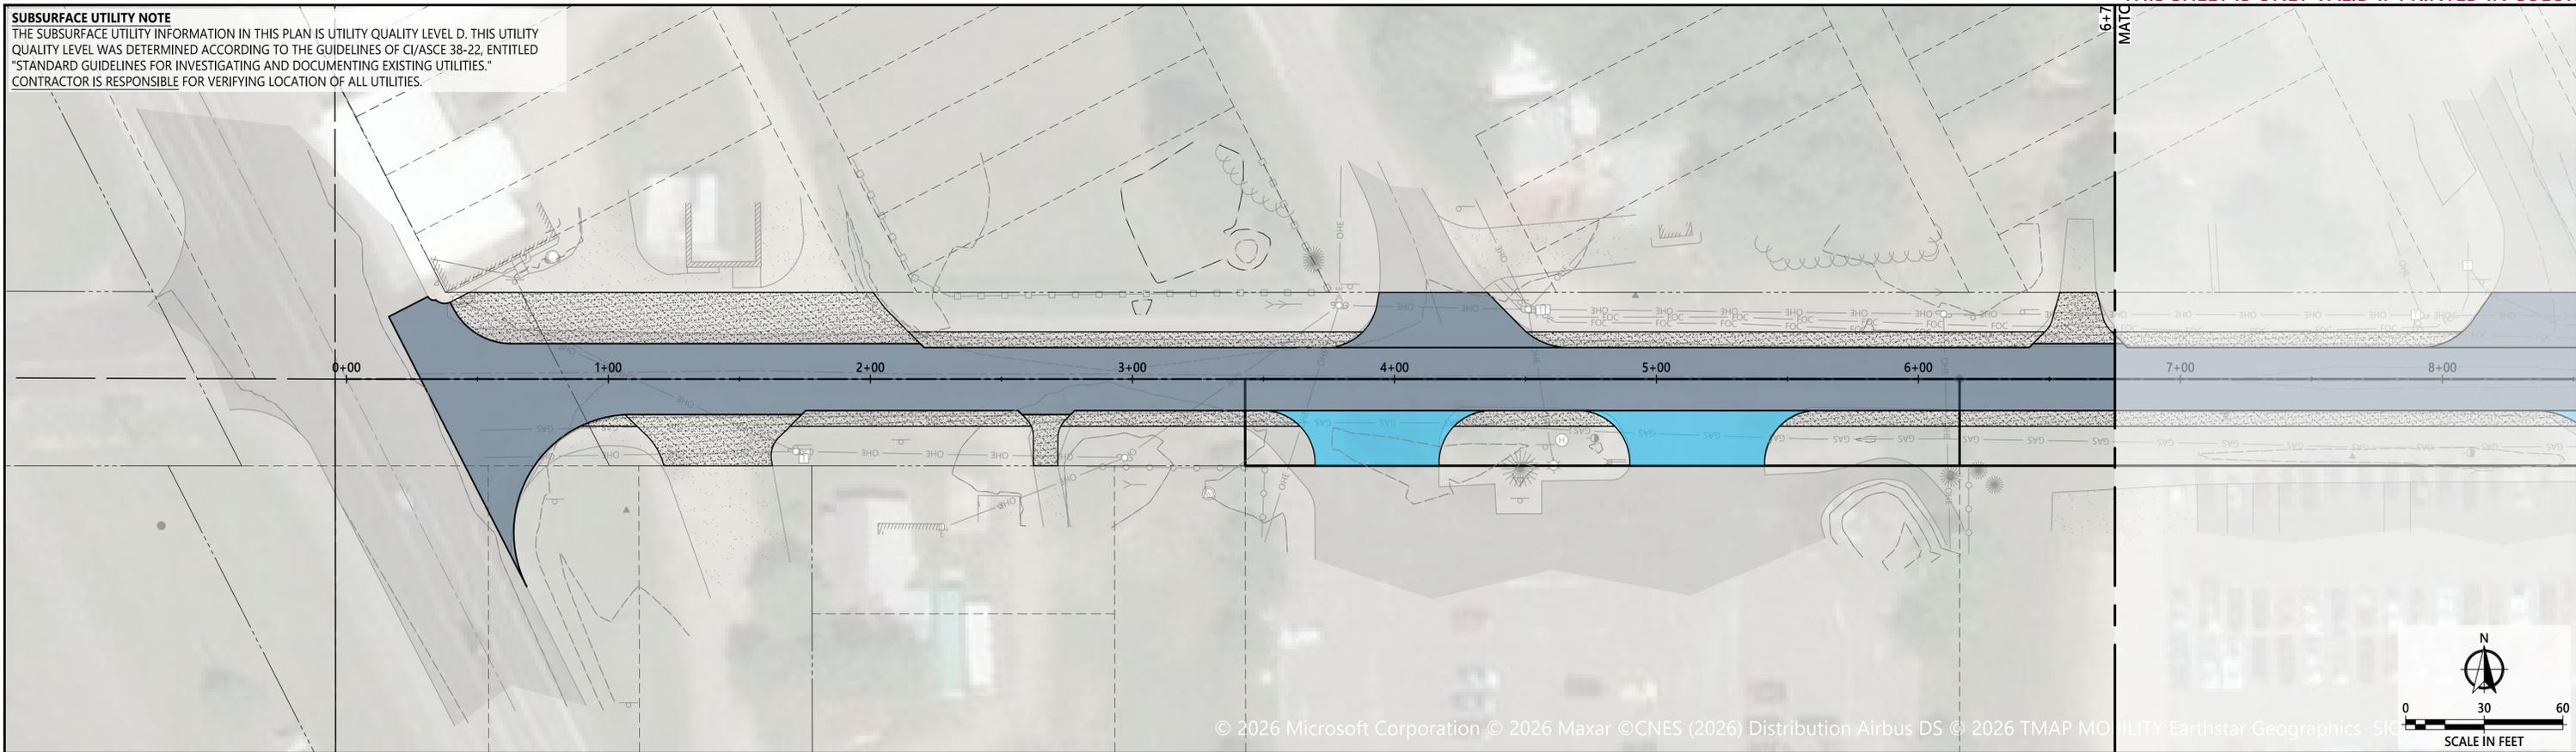

© 2026 Microsoft Corporation © 2026 Maxar ©CNES (2026) Distribution Airbus DS © 2026 TMAP MO ILITY Earthstar Geographics SIC

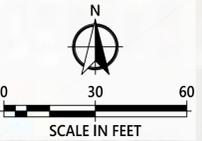

# PLAN AND PROFILE

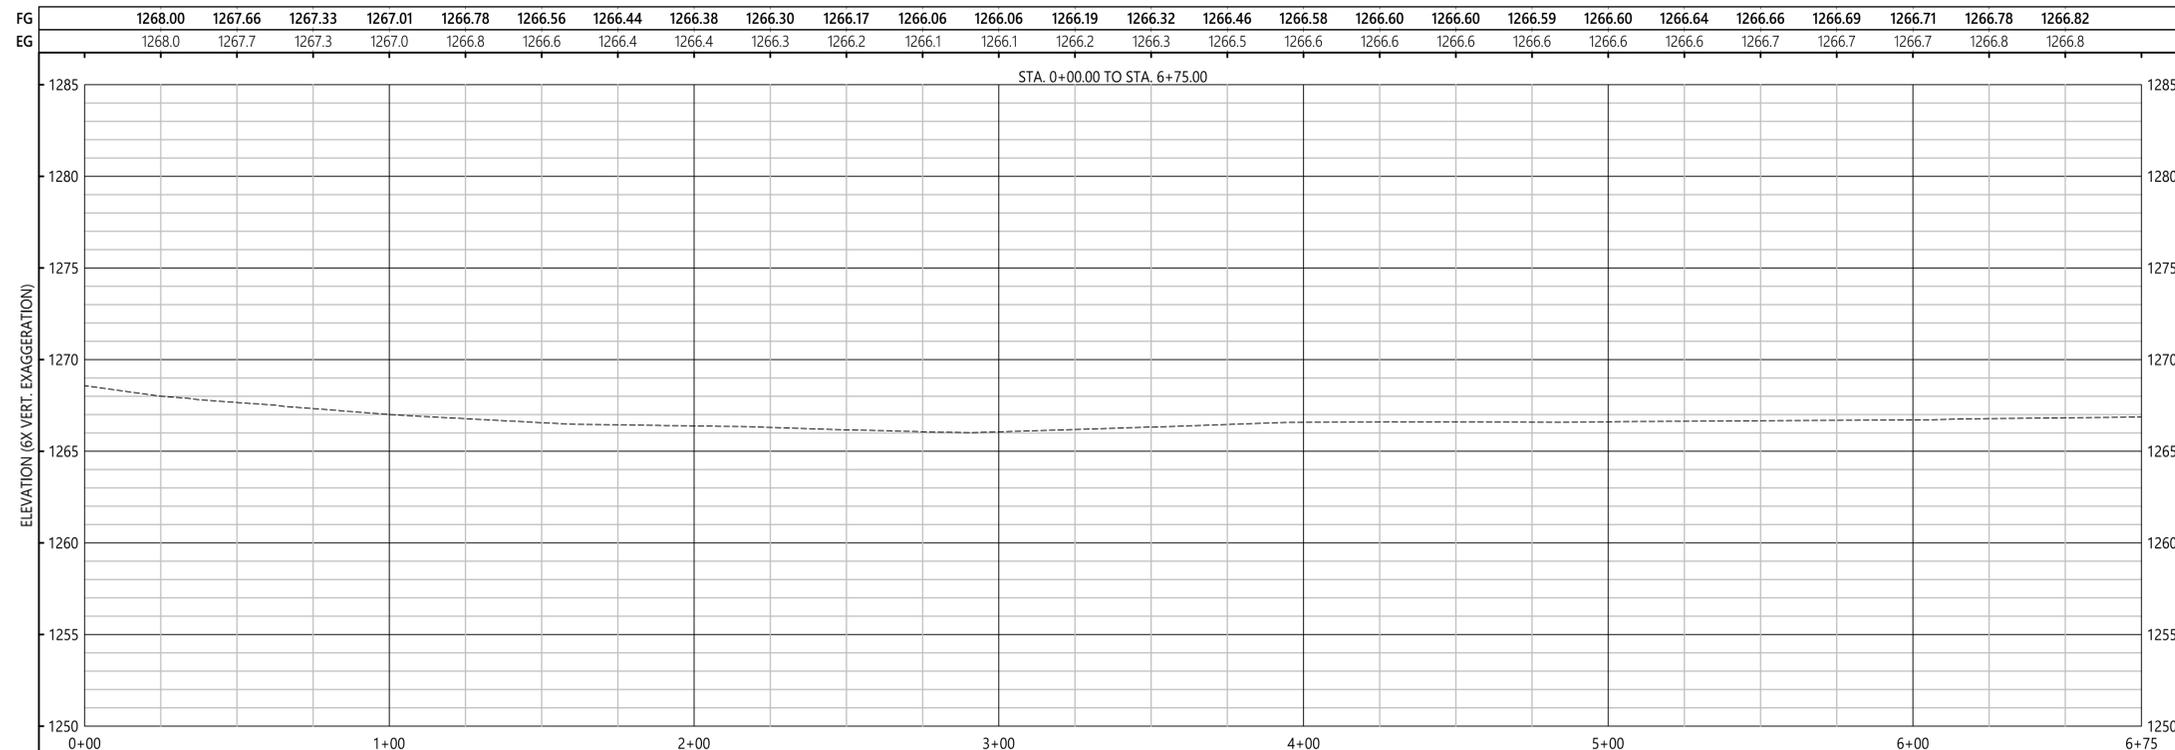

DRAWN BY:  
TMR  
CHECKED BY:  
DSR

I HEREBY CERTIFY THAT THIS PLAN, SPECIFICATION, OR REPORT WAS PREPARED BY ME OR UNDER MY DIRECT SUPERVISION AND THAT I AM A DULY LICENSED PROFESSIONAL ENGINEER UNDER THE LAWS OF THE STATE OF MINNESOTA.  
 THOMAS RIENS LIC. NO.: 63111 DATE: MM/DD/YYYY

DATE	REV#	REVISIONS DESCRIPTION


VETERANS STREET RECONSTRUCT

PLAN AND PROFILE

C6.01

PROJECT #: 2026-10527

**SUBSURFACE UTILITY NOTE**  
 THE SUBSURFACE UTILITY INFORMATION IN THIS PLAN IS UTILITY QUALITY LEVEL D. THIS UTILITY QUALITY LEVEL WAS DETERMINED ACCORDING TO THE GUIDELINES OF CI/ASCE 38-22, ENTITLED "STANDARD GUIDELINES FOR INVESTIGATING AND DOCUMENTING EXISTING UTILITIES." CONTRACTOR IS RESPONSIBLE FOR VERIFYING LOCATION OF ALL UTILITIES.

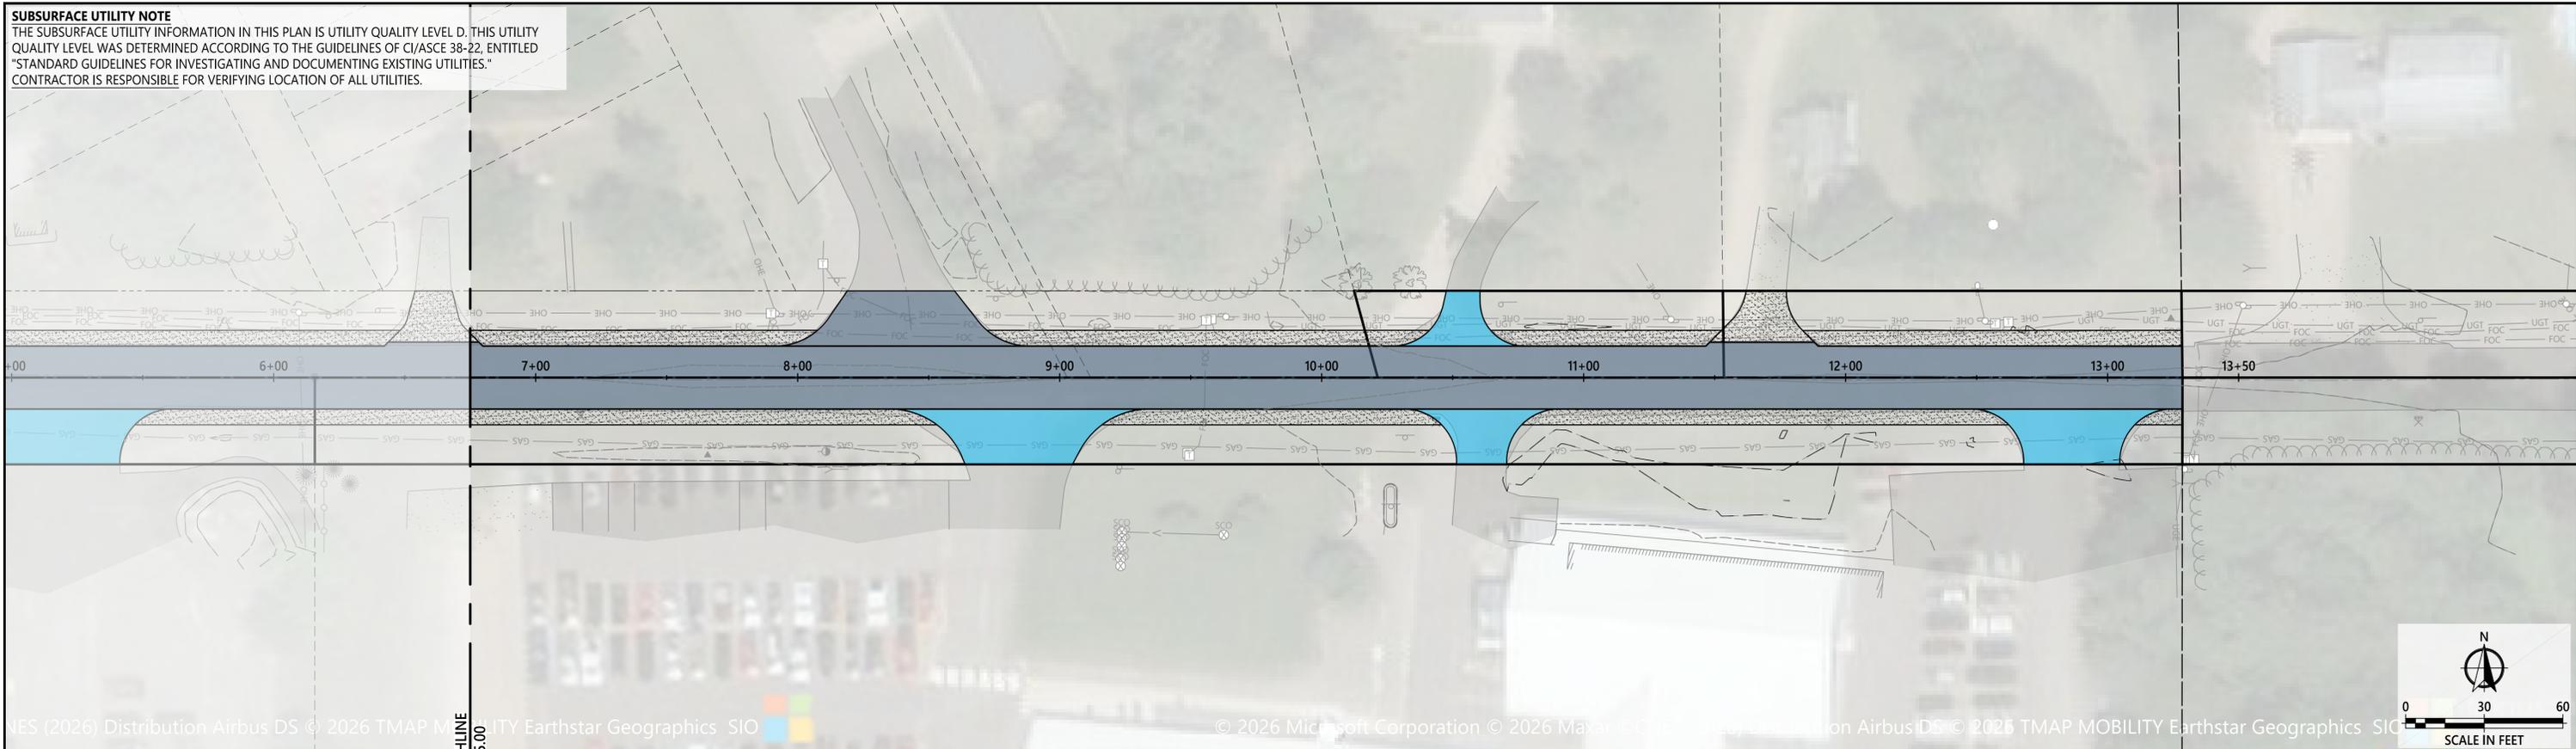

# PLAN AND PROFILE

FG	1266.94	1267.02	1267.09	1267.12	1267.13	1267.12	1267.09	1267.02	1266.96	1266.89	1266.80	1266.63	1266.46	1266.28	1266.11	1265.96	1265.95	1265.98	1266.01	1266.04	1266.03	1266.01	1266.02	1266.06	1266.11
EG	1266.9	1267.0	1267.1	1267.1	1267.1	1267.1	1267.1	1267.0	1267.0	1266.9	1266.8	1266.6	1266.5	1266.3	1266.1	1266.0	1266.0	1266.0	1266.0	1266.0	1266.0	1266.0	1266.0	1266.1	1266.1

STA. 6+75.00 TO STA. 13+48.54



DRAWN BY: TMR  
 CHECKED BY: DSR  
 THOMAS RIENS LIC. NO.: 63111 DATE: MM/DD/YYYY

DATE	REV#	REVISIONS DESCRIPTION

**VETERANS STREET RECONSTRUCT**  
 PLAN AND PROFILE

**C6.02**  
 PROJECT #: 2026-10527

© 2026 WIDSETH FILE: W:\PROJECTS\CITY OF JENKINS-32482\2026-10527\04 DESIGN\CIVIL\CADD\C-PP-2026-10527.DWG PLOTTED BY: THOMAS RIENS, March 17, 2026